




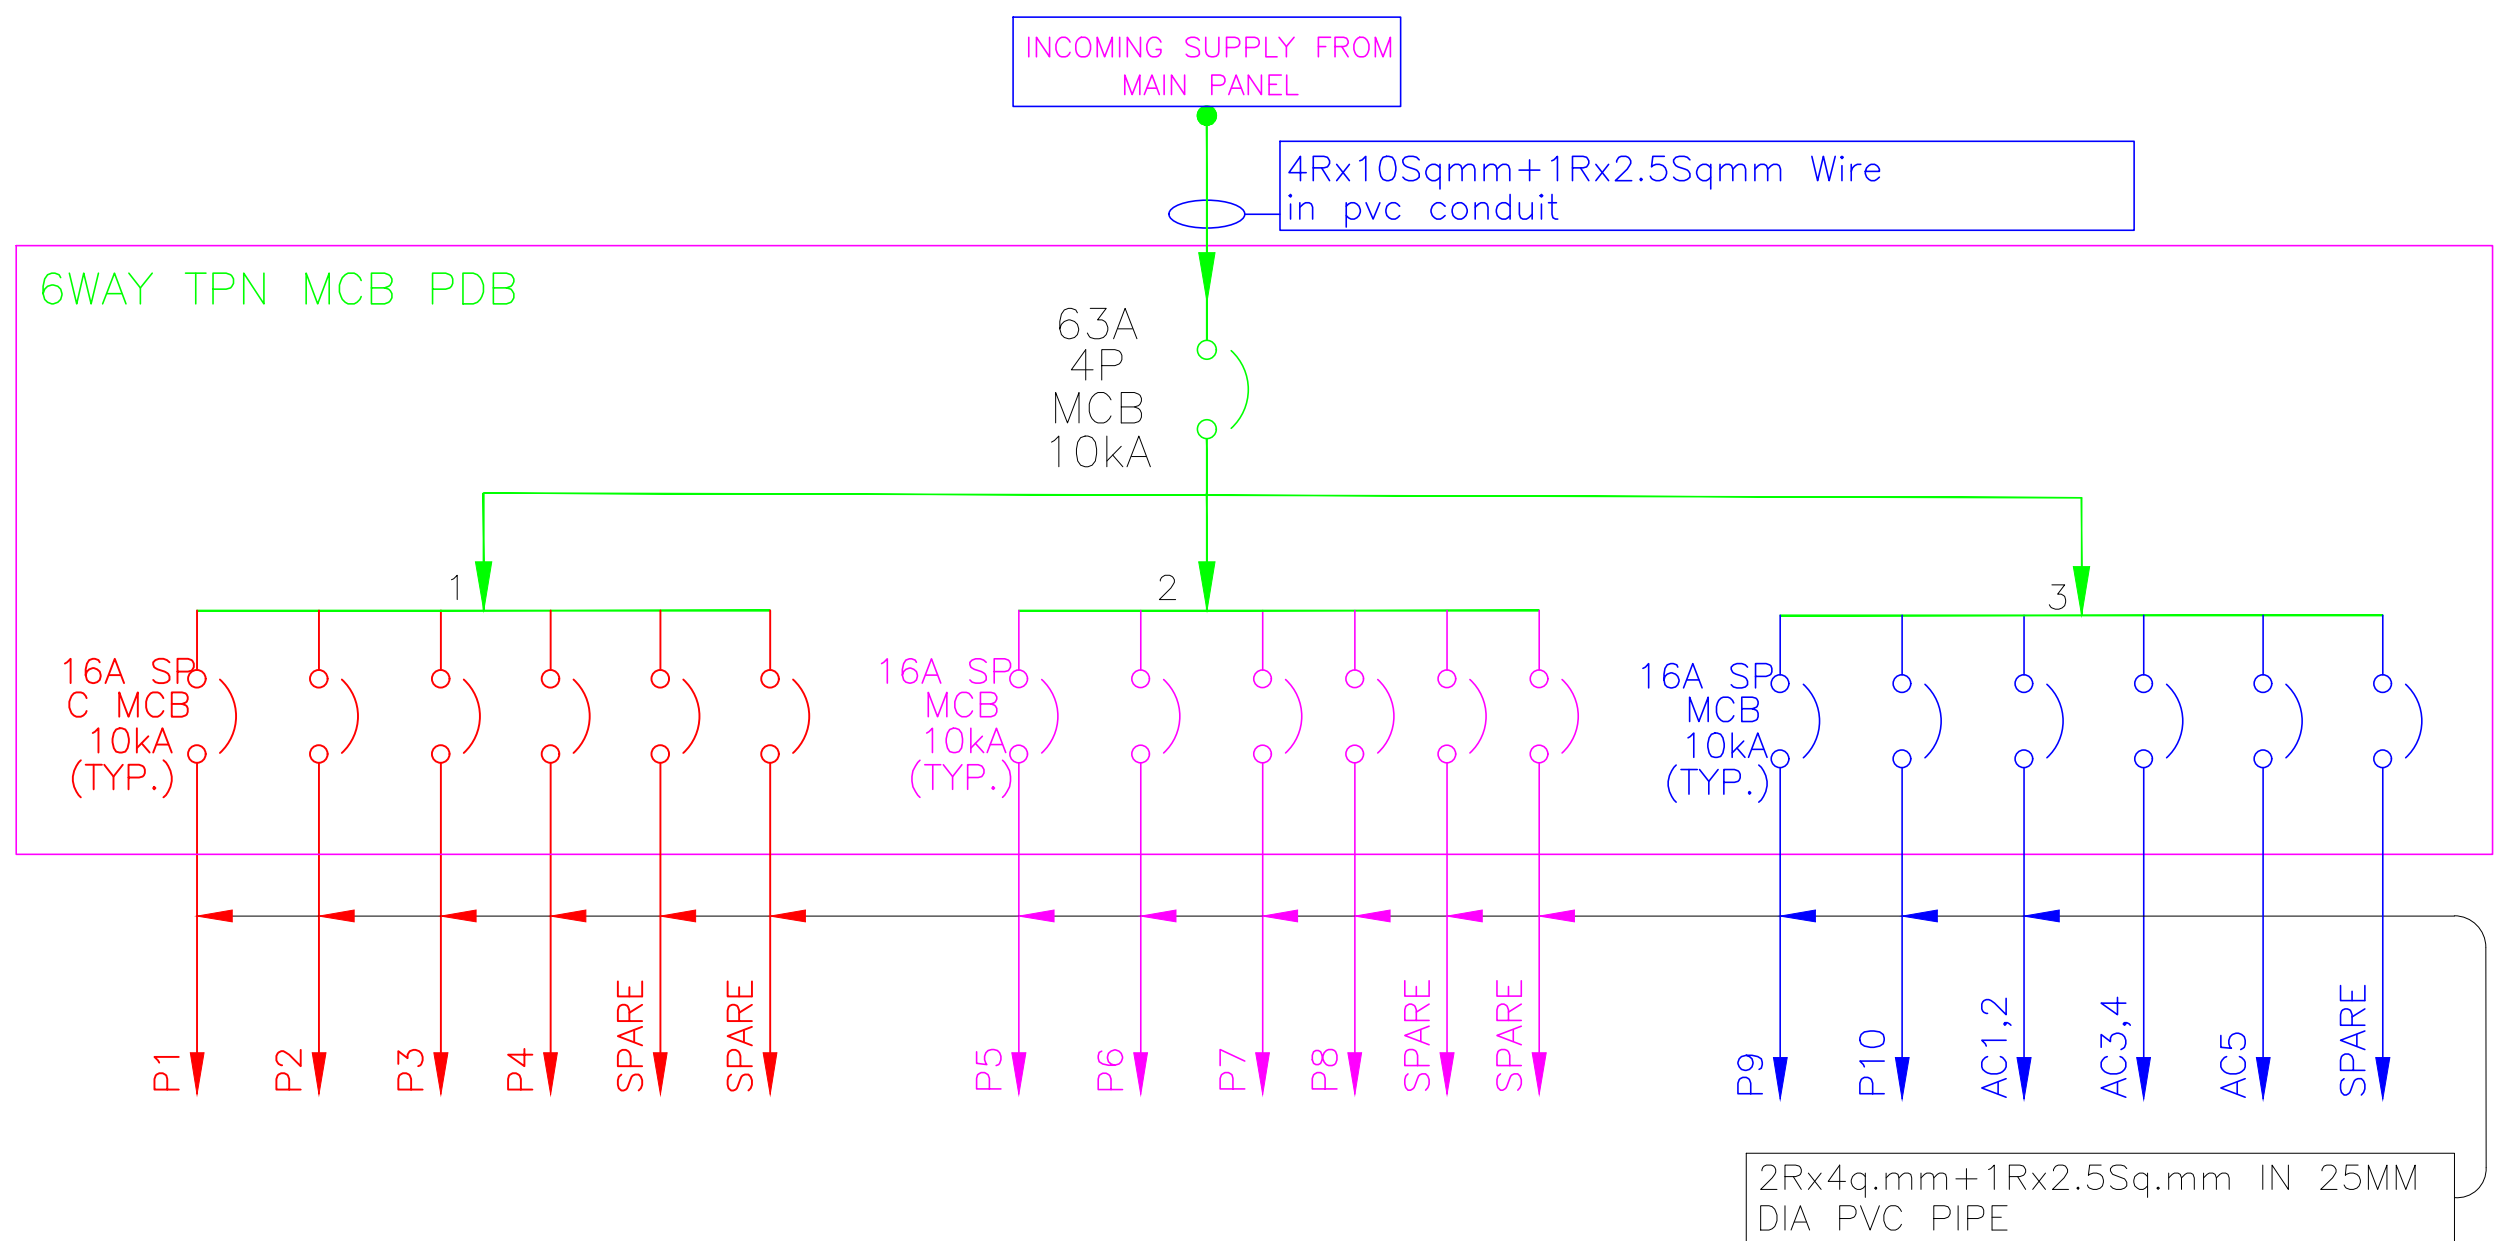

PDB DETAIL(FIRST FLOOR)


 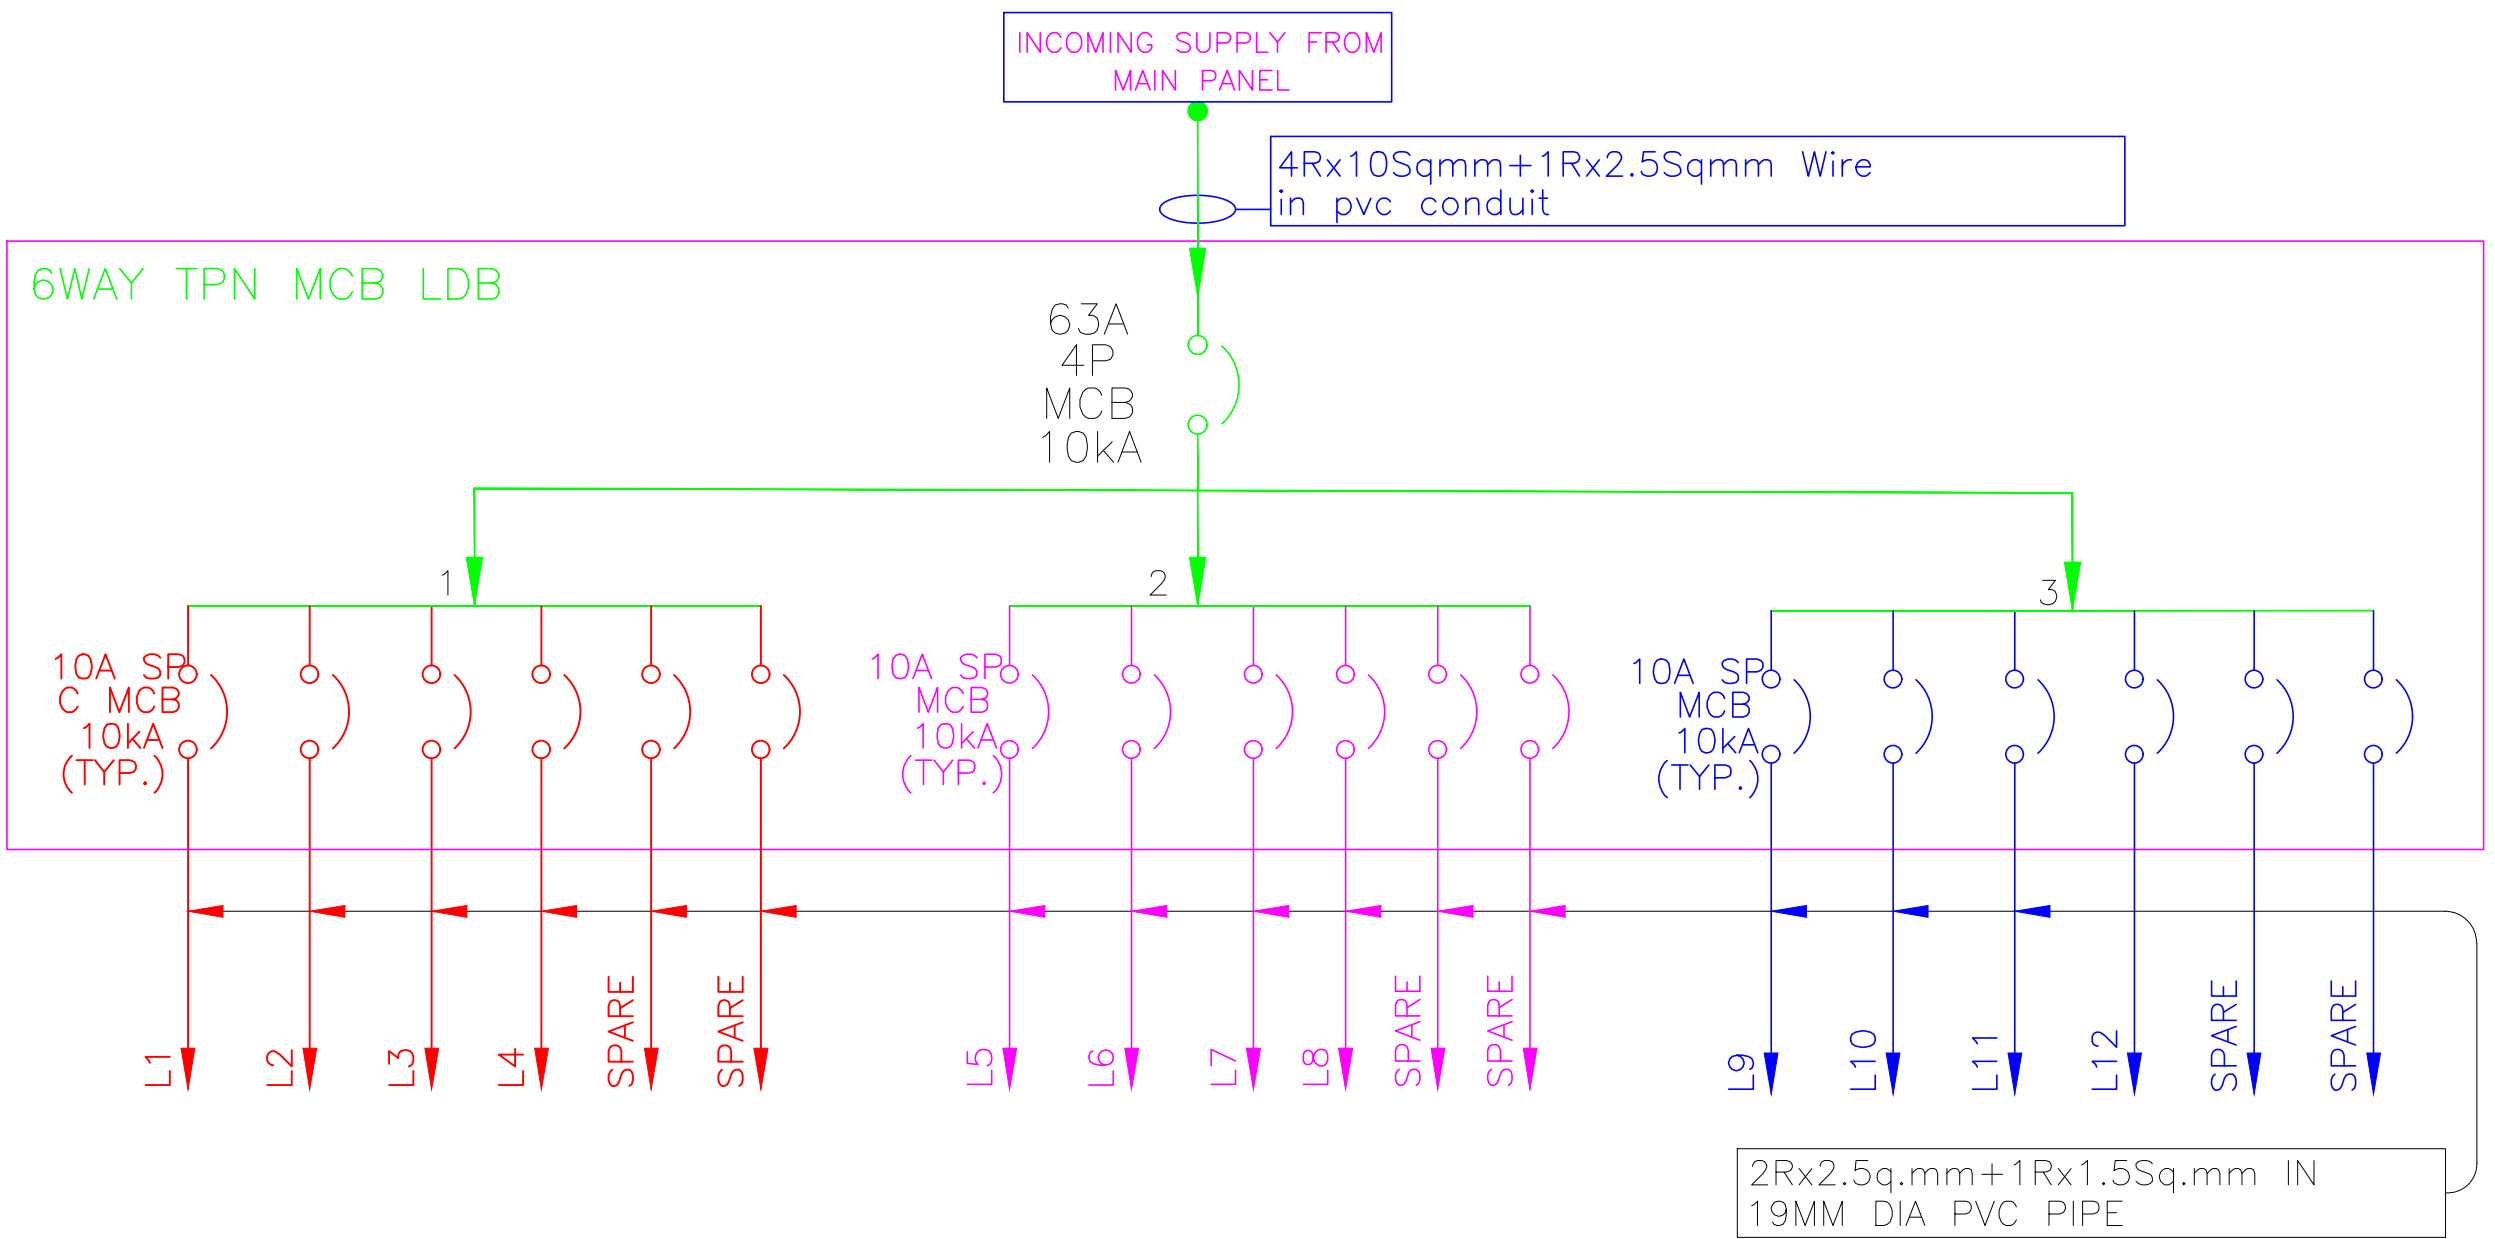


LDB DETAIL(FIRST FLOOR)

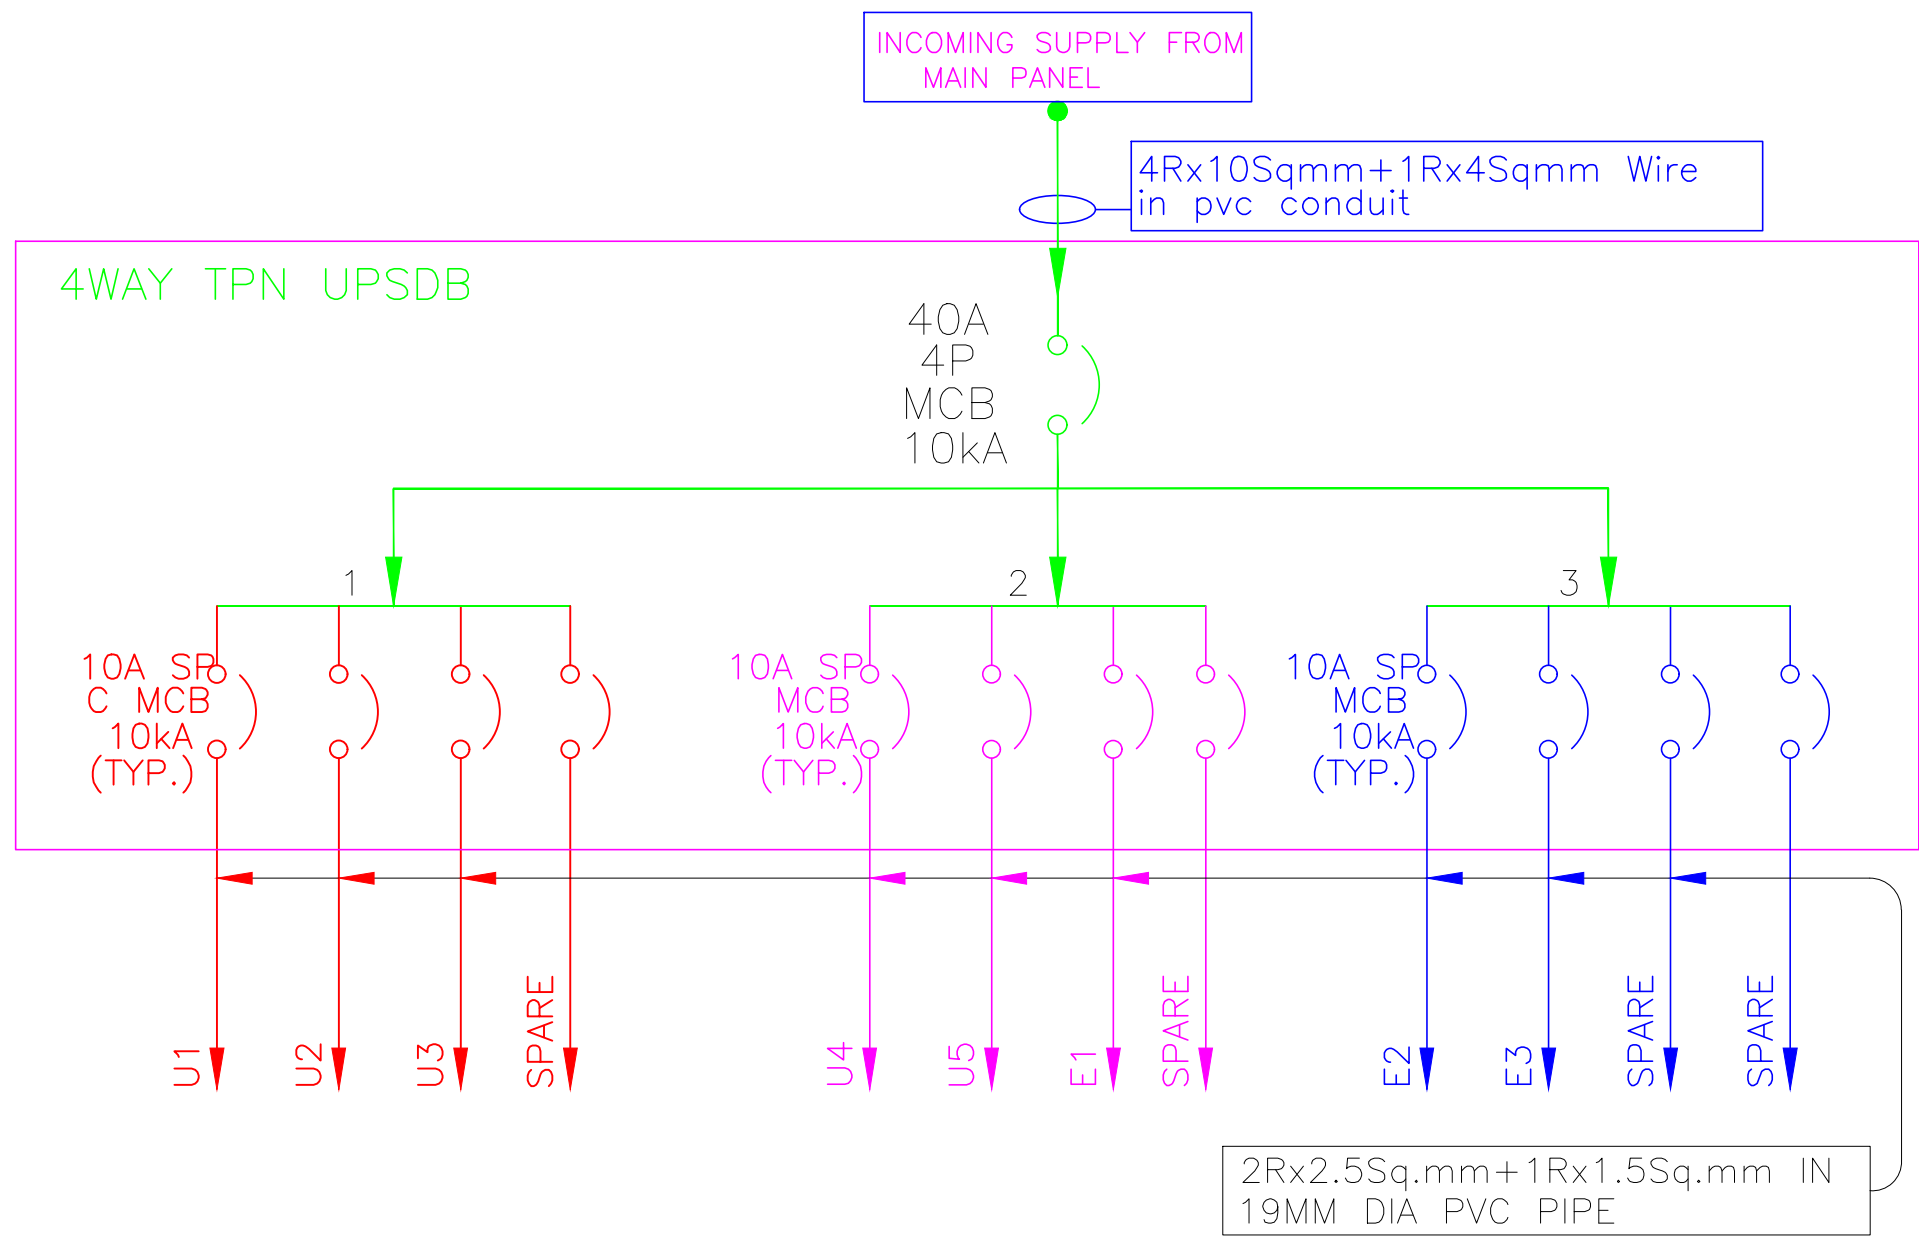

UPSDB DETAIL(FIRST FLOOR)

R1

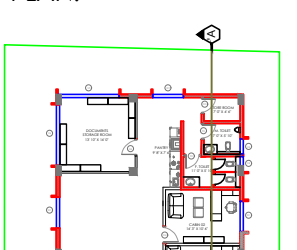NOTE: 1. THE DESIGN & DRAWING IS THE PROPERTY & COPYRIGHT OF M/s. MYRIAD GEOMETRIES/MG10 ARCHITECTURE. REPRODUCTION AND USE OF THE DESIGN, IN WHOLE OR IN PART, IS FORBIDDEN WITHOUT THE ARCHITECT'S WRITTEN CONSENT. 2. DRAWING IS NOT TO BE SCALED. 3. ALL DIMENSIONS ARE IN MILLIMETERS AND LEVELS IN METERS UNLESS NOTED OTHERWISE. 4. ANY DISCREPANCIES IN THE DRAWING SHALL BE BROUGHT TO THE NOTICE OF THE ARCHITECT BEFORE EXECUTION. ALL DIMENSIONS TO BE VERIFIED ON SITE AND APPROVED BY THE ARCHITECT/PROJECT MANAGER. 5. DRAWING SHOULD BE READ IN CONJUNCTION WITH OTHER RELEVANT ARCHITECTURAL, STRUCTURAL, MECHANICAL AND ELECTRICAL DRAWINGS AND ALL RELEVANT SECTIONS OF THE SPECIFICATIONS.	LEGEND / SYMBOLS 1.LEVELS IN PLANS/ELEVATIONS/SECTIONS + FFL + SSL FINISHED FLOOR LEVEL STRUCTURAL SLAB LEVEL + FGL FORMATION GROUND LEVEL 2.DOORS 100 100 100 100 100 DOOR TYPES DRAWING NUMBERS 3.SECTIONS 100 100 100 100 100 SECTION NUMBERS DRAWING NUMBERS 4.ELEVATIONS 100 100 100 100 100 ELEVATION NUMBERS DRAWING NUMBERS	WIRING <table><thead><tr><th>SL.No</th><th>DESCRIPTION</th><th>WIRE SIZE</th><th>Conduit pipe size</th></tr></thead><tbody><tr><td>1</td><td>MDB To LPDB</td><td>4x6sqmm+1x2.5sqmm</td><td>25mmdia</td></tr><tr><td></td><td>MDB To UDB</td><td>2x4sqmm+1x2.5sqmm</td><td>25mmdia</td></tr><tr><td>2</td><td>LDB to 15A Socket</td><td>2x4sqmm+1x2.5sqmm</td><td>25mmdia</td></tr><tr><td>3</td><td>LDB to SB & 5A Socket</td><td>2x2.5sqmm+1x1.5sqmm</td><td>20mmdia</td></tr><tr><td>4</td><td>SB to Point wiring</td><td>2x1.5sqmm+1x1.0sqmm</td><td>20/25mmdia</td></tr><tr><td>5</td><td>Telephone wiring /TV wiring</td><td>2pair telephone cable/ TV Cable - RG6</td><td>25mmdia</td></tr><tr><td>6</td><td>Earthing</td><td>8SWG GI WIRE</td><td></td></tr></tbody></table>				SL.No	DESCRIPTION	WIRE SIZE	Conduit pipe size	1	MDB To LPDB	4x6sqmm+1x2.5sqmm	25mmdia		MDB To UDB	2x4sqmm+1x2.5sqmm	25mmdia	2	LDB to 15A Socket	2x4sqmm+1x2.5sqmm	25mmdia	3	LDB to SB & 5A Socket	2x2.5sqmm+1x1.5sqmm	20mmdia	4	SB to Point wiring	2x1.5sqmm+1x1.0sqmm	20/25mmdia	5	Telephone wiring /TV wiring	2pair telephone cable/ TV Cable - RG6	25mmdia	6	Earthing	8SWG GI WIRE		KEY PLAN: 	<table><tr><td>SCALE</td><td>NoI To Scale</td></tr><tr><td>DATE</td><td>08 MAR 2026</td></tr><tr><td>DRAWN</td><td>RAGHU</td></tr><tr><td>CHECKED</td><td>RAGHU</td></tr><tr><td>SIGNATURE</td><td>-</td></tr></table> PROJECT: PROPOSED COMMERCIAL DEVELOPMENT FOR KSSFCL at Vishveshwar Nagar, Mysuru - 570008 STRUCTURAL CONSULTANT :  NESTA PROJECTS Shivamogga	SCALE	NoI To Scale	DATE	08 MAR 2026	DRAWN	RAGHU	CHECKED	RAGHU	SIGNATURE	-	<table><tr><td>SHEET SIZE</td><td>A1</td></tr></table> CLIENT: KARNATAKA STATE SOUHARDA FEDERAL CO-OPERATIVE LTD. Mangrosa Road,Malleshwaram, Bengaluru - 560003 MEP CONSULTANT : M/s GR ENGINEERS Bengaluru	SHEET SIZE	A1	DRAWING TITLE ELECTRICAL LAYOUT		REV NO R0
		SL.No	DESCRIPTION	WIRE SIZE	Conduit pipe size																																																		
		1	MDB To LPDB	4x6sqmm+1x2.5sqmm	25mmdia																																																		
			MDB To UDB	2x4sqmm+1x2.5sqmm	25mmdia																																																		
2	LDB to 15A Socket	2x4sqmm+1x2.5sqmm	25mmdia																																																				
3	LDB to SB & 5A Socket	2x2.5sqmm+1x1.5sqmm	20mmdia																																																				
4	SB to Point wiring	2x1.5sqmm+1x1.0sqmm	20/25mmdia																																																				
5	Telephone wiring /TV wiring	2pair telephone cable/ TV Cable - RG6	25mmdia																																																				
6	Earthing	8SWG GI WIRE																																																					
SCALE	NoI To Scale																																																						
DATE	08 MAR 2026																																																						
DRAWN	RAGHU																																																						
CHECKED	RAGHU																																																						
SIGNATURE	-																																																						
SHEET SIZE	A1																																																						
FIRST FLOOR PLAN DB DETAILS																																																							
DRAWING NUMBER KS		AR/FP/FF/ELEC/01																																																					
ARCHITECTS  MYRIAD ARCHITECTS INTERIORS GRAPHIC DESIGN																																																							