


16145 [53']

30534 [100'-2"]

LEGEND	
SYMBOL	DESCRIPTION
	CEILING TUBE LIGHT + BATTEN HOLDER
	WALL TUBE LIGHT + BATTEN HOLDER
	WALL CFL + BATTEN HOLDER
	CEILING CFL + BATTEN HOLDER
	STREET LIGHT FITTING
	BULK HEAD FITTING
	CEILING FAN + REGULATOR
	EXHAUST FAN + CEILING ROSE
	15A UNIVERSAL SOCKET+ 15A SWITCH
	32A DP SWITCH
	6A 3PIN SOCKET WITH SWITCH ON RAW POWER
	6A 3PIN SOCKET WITHOUT SWITCH ON RAW POWER
	1NO. 6A 3PIN SOCKET WITH SWITCH ON UPS
	DATA POINT
	TELEPHONE POINT
	TV POINT
	CCTV
	5A SWITCHES
	2 WAY SWITCHES
	MIRROR LIGHT FIXTURE
	UPS DISTRIBUTION BOARD
	LIGHTING POWER DISTRIBUTION BOARD
	MAIN DISTRIBUTION BOARD
	EARTHING
	8SWG GI WIRE
	GI PIPE

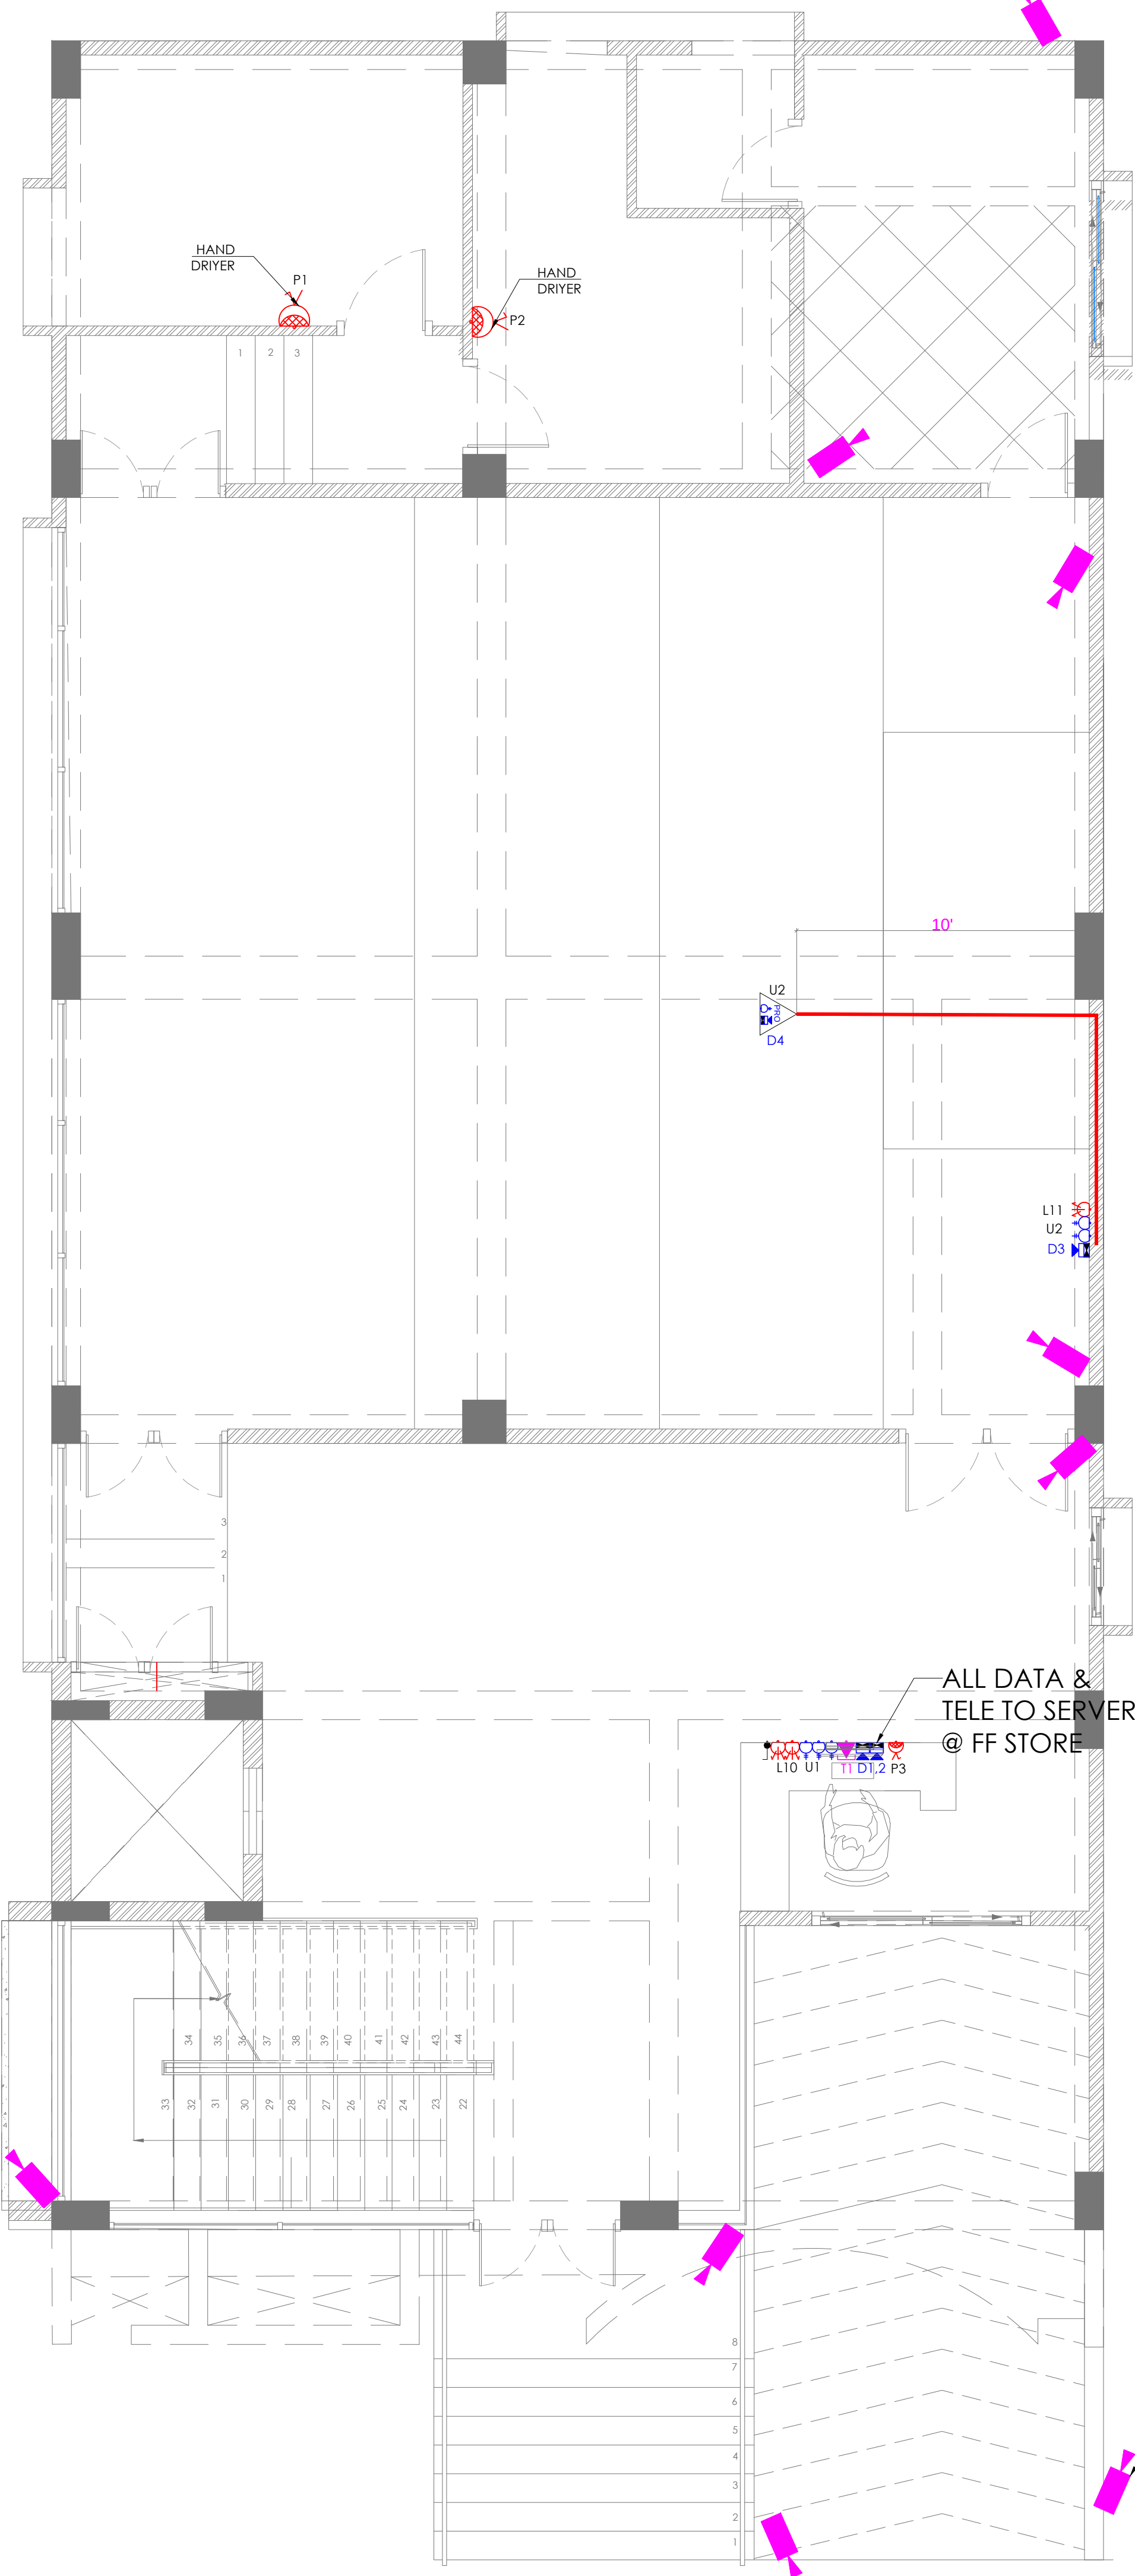

ALL CAMERA
TO NVR @ FF
STORE

ALL DATA &
TELE TO SERVER
@ FF STORE

TRANSFORMER
UNIT

+150 MM

12 METER ROAD +00 MM

R1

NOTE:


1. THE DESIGN & DRAWING IS THE PROPERTY & COPYRIGHT OF M/S. MYRIAD GEOMETRIES/MS10 ARCHITECTURE. REPRODUCTION AND USE OF THE DESIGN, IN WHOLE OR IN PART, IS FORBIDDEN WITHOUT THE ARCHITECT'S WRITTEN CONSENT.
2. DRAWING IS NOT TO BE SCALED.
3. ALL DIMENSIONS ARE IN MILLIMETERS AND LEVELS IN METERS UNLESS NOTED OTHERWISE.
4. ANY DISCREPANCIES IN THE DRAWING SHALL BE BROUGHT TO THE NOTICE OF THE ARCHITECT BEFORE EXECUTION. ALL DIMENSIONS TO BE VERIFIED ON SITE AND APPROVED BY THE ARCHITECT/PROJECT MANAGER.
5. DRAWING SHOULD BE READ IN CONJUNCTION WITH OTHER RELEVANT ARCHITECTURAL, STRUCTURAL, MECHANICAL AND ELECTRICAL DRAWINGS AND ALL RELEVANT SECTIONS OF THE SPECIFICATIONS.

LEGEND / SYMBOLS

- 1.LEVELS IN PLANS/ELEVATIONS/SECTIONS
 - FINISHED FLOOR LEVEL
 - STRUCTURAL SLAB LEVEL
 - FORMATION GROUND LEVEL
- 2.DOORS
 - DOOR TYPES
 - DRAWING NUMBERS
- 3.SECTIONS
 - SECTION NUMBERS
 - DRAWING NUMBERS
- 4.ELEVATIONS
 - ELEVATION NUMBERS
 - DRAWING NUMBERS

WIRING			
Sl.No	DESCRIPTION	WIRE SIZE	Conduit pipe size
1	MDB To LPDB	4x6sqmm+1x2.5sqmm	25mmdia
	MDB To UDB	2x4sqmm+1x2.5sqmm	25mmdia
2	LDB to 15A Socket	2x4sqmm+1x2.5sqmm	25mmdia
3	LDB to SB & 5A Socket	2x2.5sqmm+1x1.5sqmm	20mmdia
4	SB to Point wiring	2x1.5sqmm+1x1.0sqmm	20/25mmdia
5	Telephone wiring /TV wiring	2pair telephone cable/ TV Cable - RG6	25mmdia
6	Earthing	8SWG GI WIRE	

KEY PLAN:

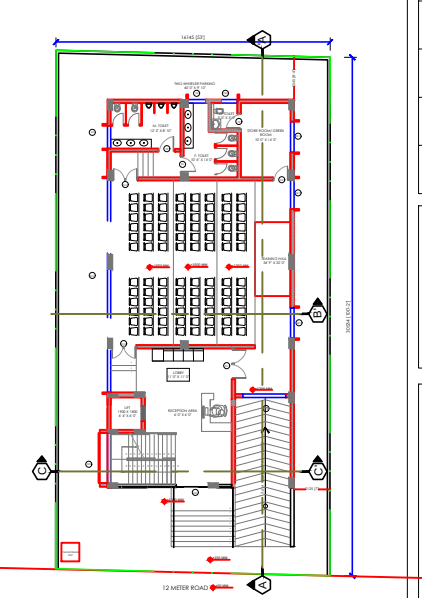

SCALE	Not To Scale
DATE	16 DEC 2025
DRAWN	RAGHU
CHECKED	RAGHU
SIGNATURE	-
PROJECT: PROPOSED COMMERCIAL DEVELOPMENT FOR KSFCL at Vishveshwar Nagar, Mysuru - 570008	
STRUCTURAL CONSULTANT : NESTA PROJECTS Shivamogga	

SHEET SIZE	A1
CLIENT: KARNATAKA STATE SOUHARDA FEDERAL CO-OPERATIVE LTD. Margosa Road, Malleshwaram, Bengaluru - 560003	
MEP CONSULTANT : M/s GR ENGINEERS Bengaluru	

DRAWING TITLE		ELECTRICAL LAYOUT	
GROUND FLOOR PLAN PWR/CCTV/DATA/UPS CIRCUIT LAYOUT		REV NO	R0
DRAWING NUMBER	KS	AR/FP/GF/ELEC/01	
ARCHITECTS MYRIAD ARCHITECTS PRACTICE			